



berry architecture  
+associates

Berry Architecture + Associates  
Suite 200, 5218-50 Avenue  
Red Deer, T4N 4B5


Phone: 403.314.4461  
Contact: Dustin Lendvay - Project Manager

| ARCHITECTURAL SHEET LIST |            |
|--------------------------|------------|
| Sheet Number             | Sheet Name |
| A0.0                     | TITLE PAGE |
| A2.0                     | SITE PLAN  |



Polar Engineering  
722 Cormorant St #300, Victoria, BC V8W 4A5  
Phone: 778-700-1086

Contact: Nathaniel Green


| MECHANICAL SHEET LIST |                       |
|-----------------------|-----------------------|
| Sheet Number          | Sheet Name            |
| M0                    | TITLE PAGE            |
| M1                    | F&I - DEMOLITION      |
| M2                    | F&I - NEW             |
| M3                    | DETAILS AND SCHEDULES |

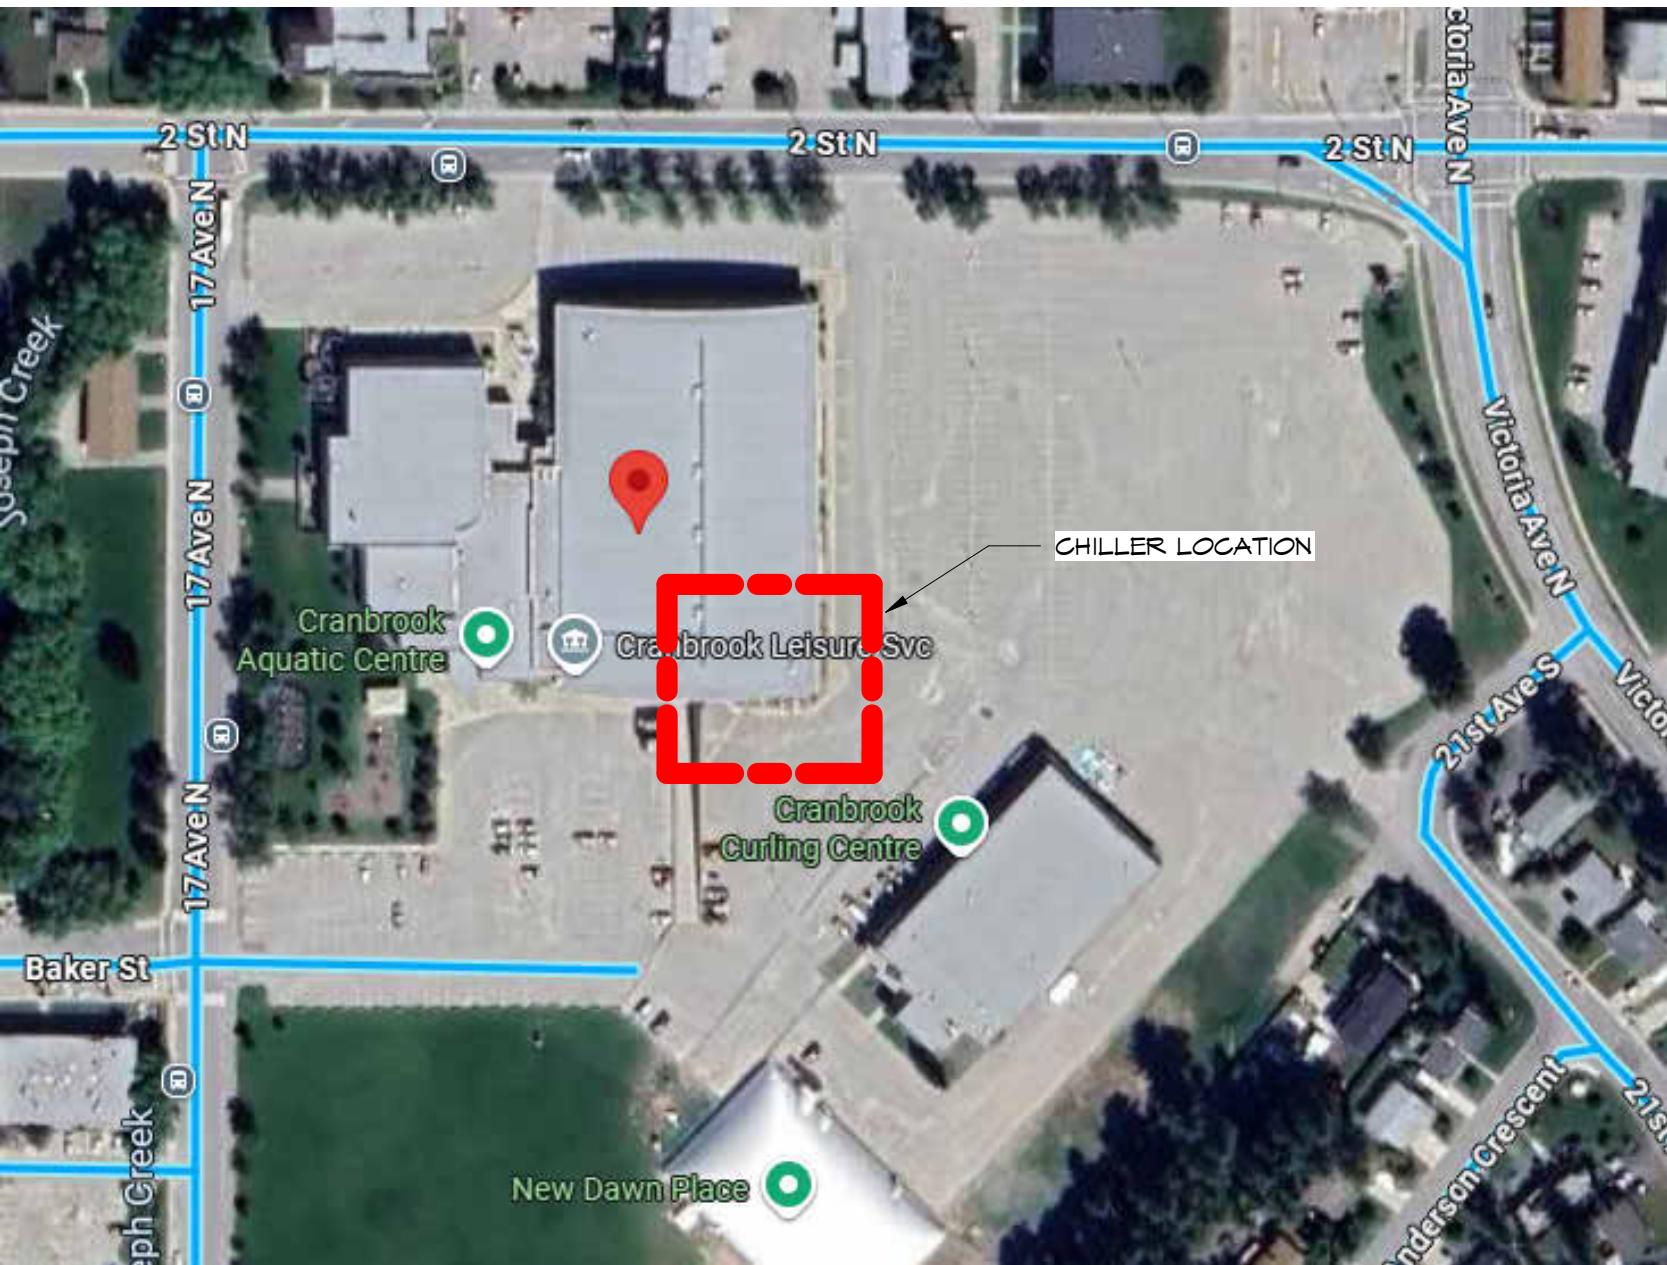


SITE CONTEXT

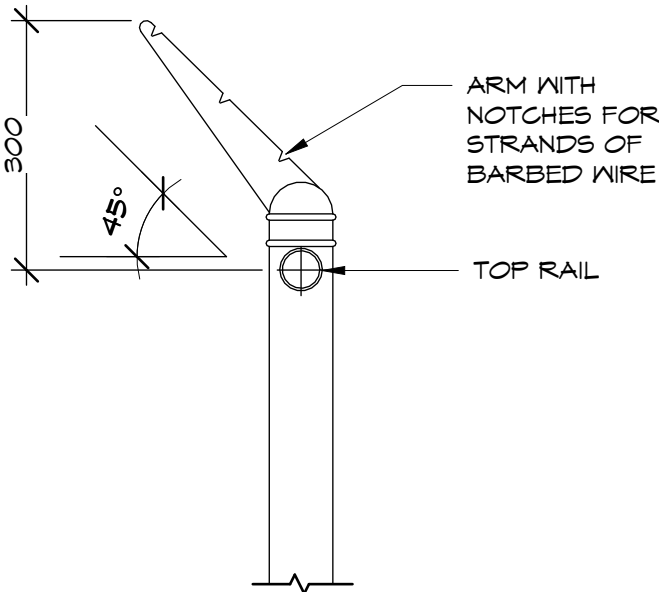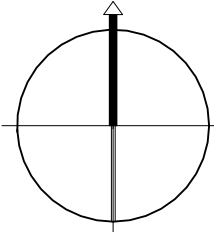

A3  
A0.0  
EXTENSION ARM DETAIL  
SCALE = 1 : 10

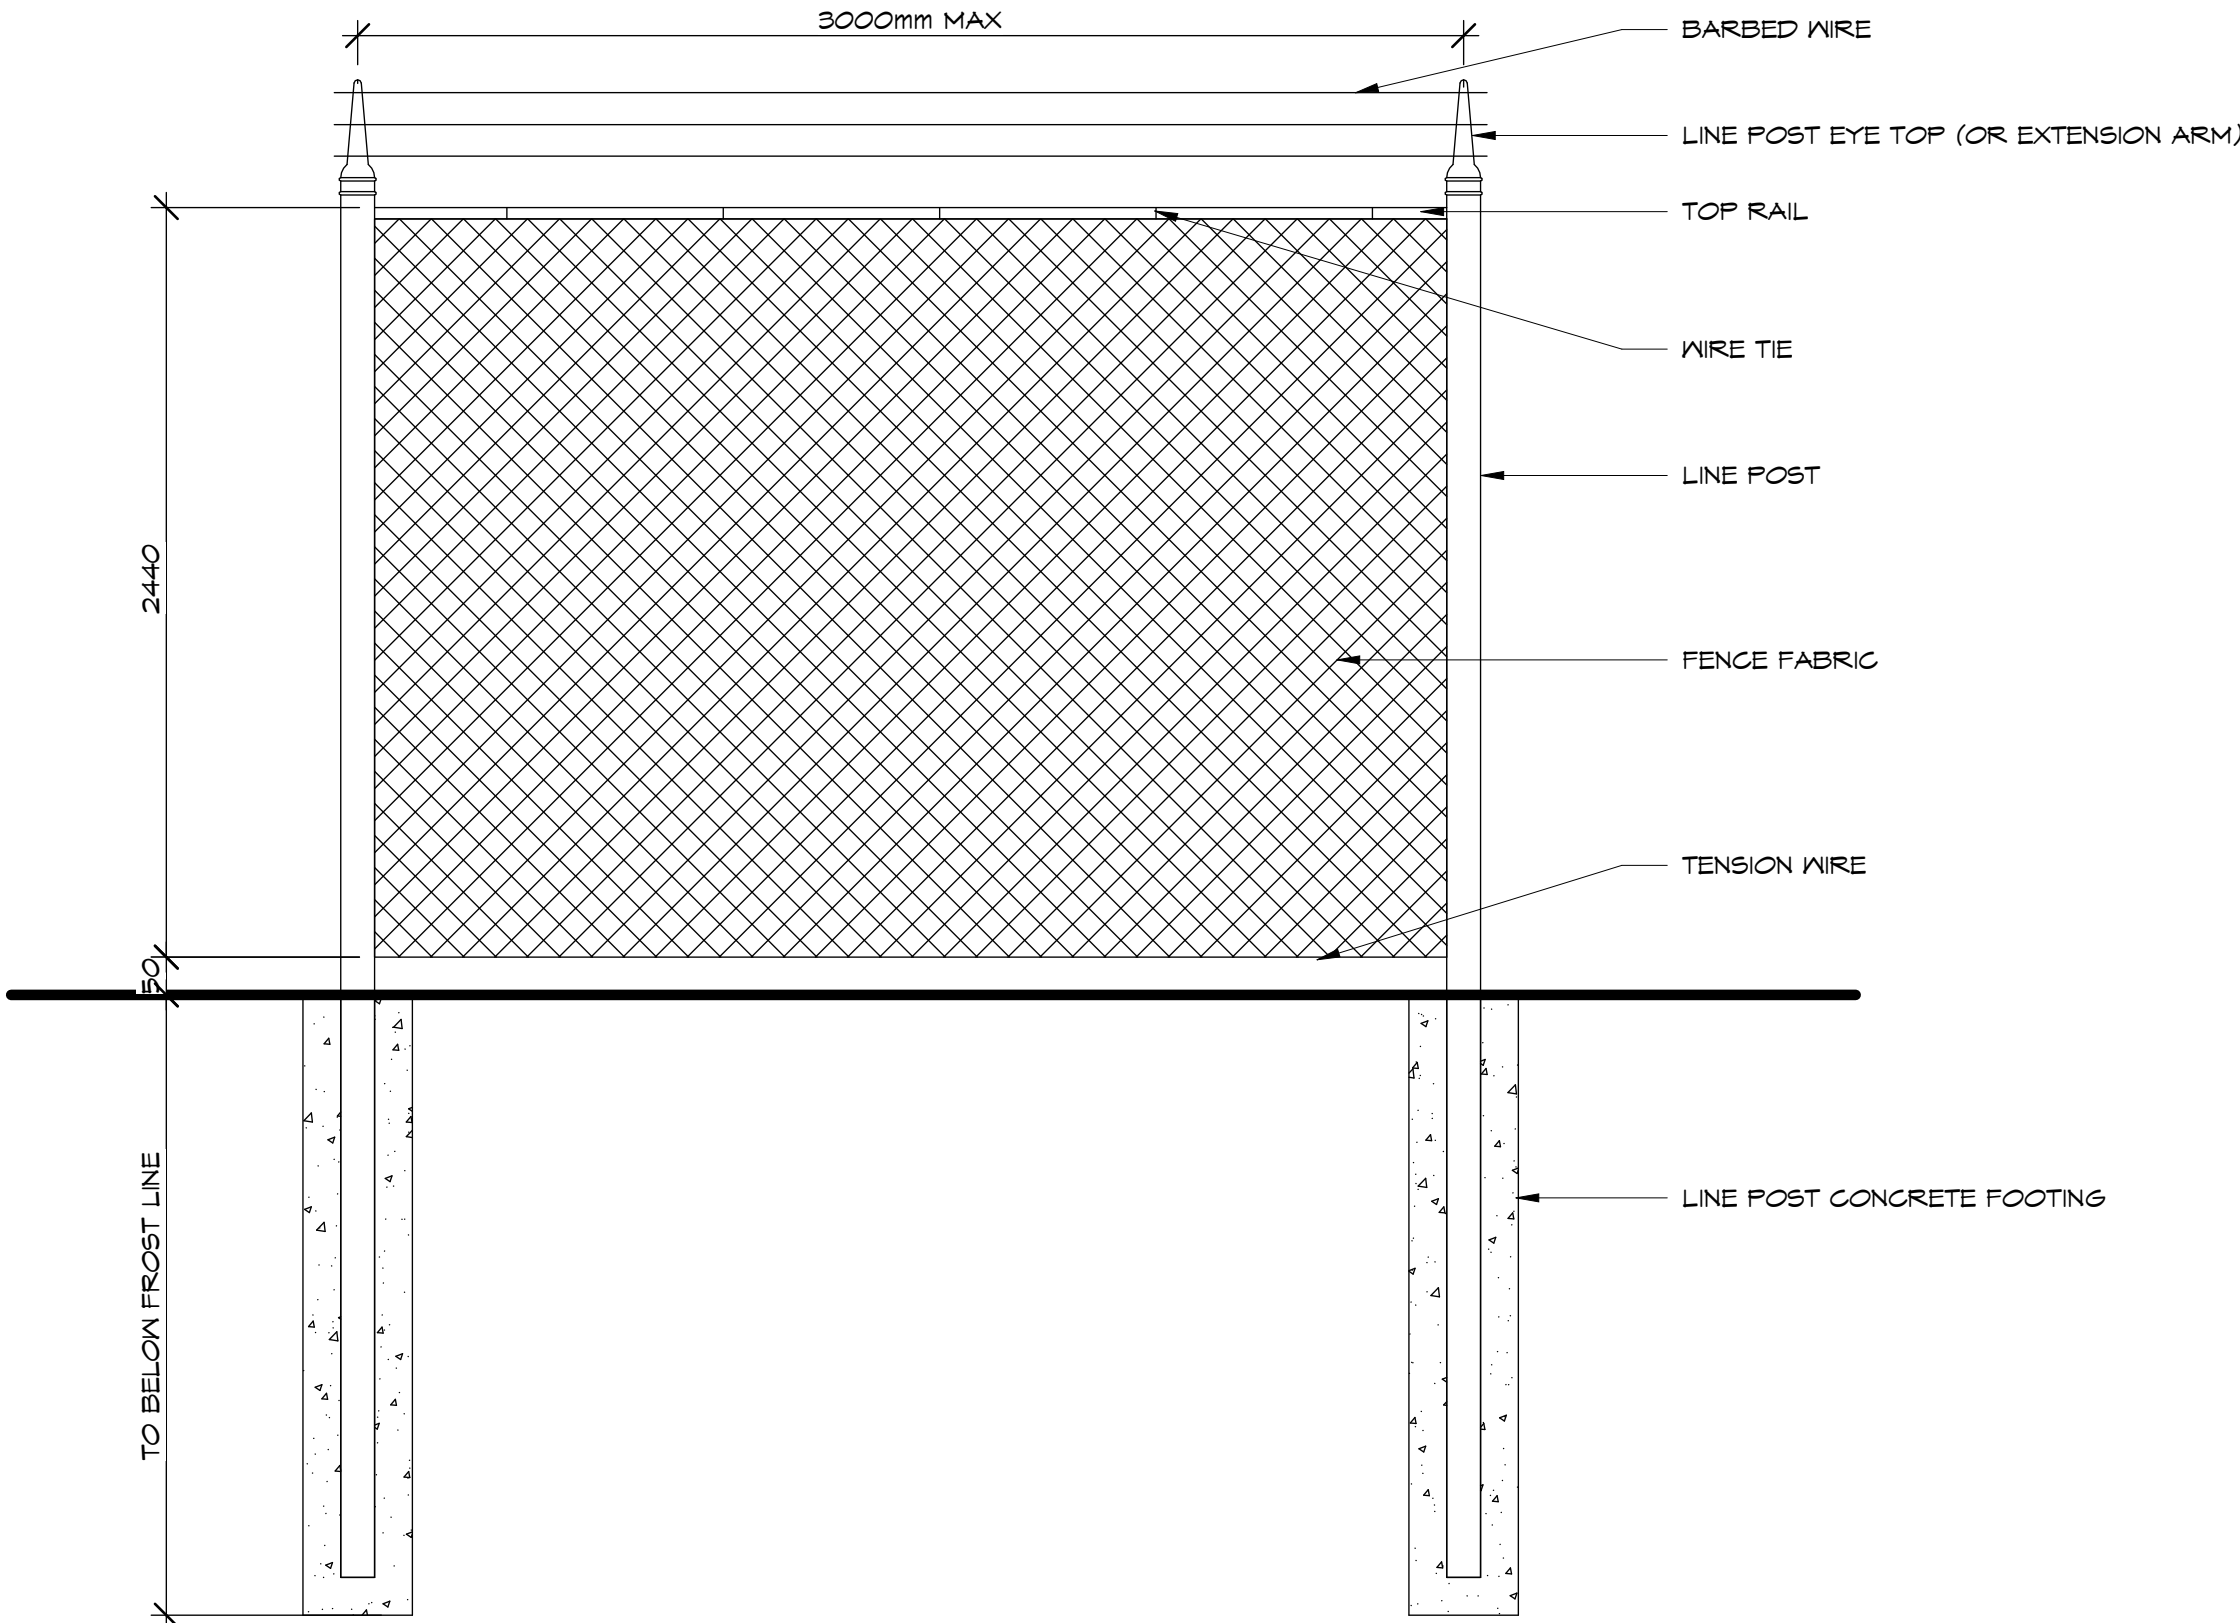

A4  
A0.0  
CHAINLINK FENCE ELEVATION  
SCALE = 1 : 10

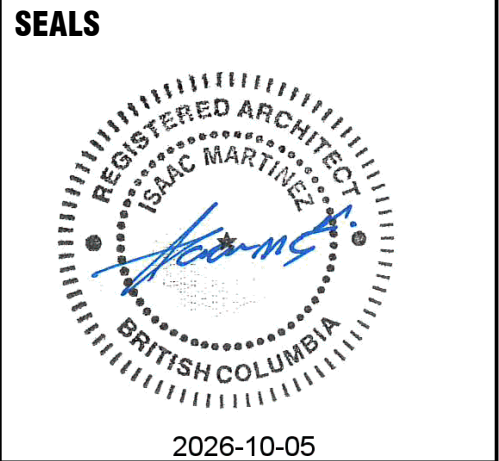

© THIS IS A COPYRIGHT DRAWING AND SHALL NOT BE REPRODUCED OR REVISED WITHOUT WRITTEN PERMISSION OF BERRY ARCHITECTURE + ASSOCIATES LTD.

| KEY PLAN |  |
|----------|--|
|          |  |

| REVISIONS + ISSUES |            |
|--------------------|------------|
| YYYY MM DD         | ISSUED FOR |
| 2026 10 06         | IFT        |

PROJECT TITLE  
**Western Financial Place  
- Evaporative Condenser  
Replacement  
1777 2 St N  
Cranbrook, BC, V1C 3G9**

DRAWING TITLE  
**TITLE PAGE**

|          |             |
|----------|-------------|
| SCALE:   | 1 : 10      |
| DRAWN:   | DL / BK     |
| CHECKED: | DL / IM     |
| Oct '25  | <b>A0.0</b> |
| 25-063   |             |

© BERRY ARCHITECTURE + ASSOCIATES LTD.


2026-10-05 3:15:55 PM

D

C

B

A

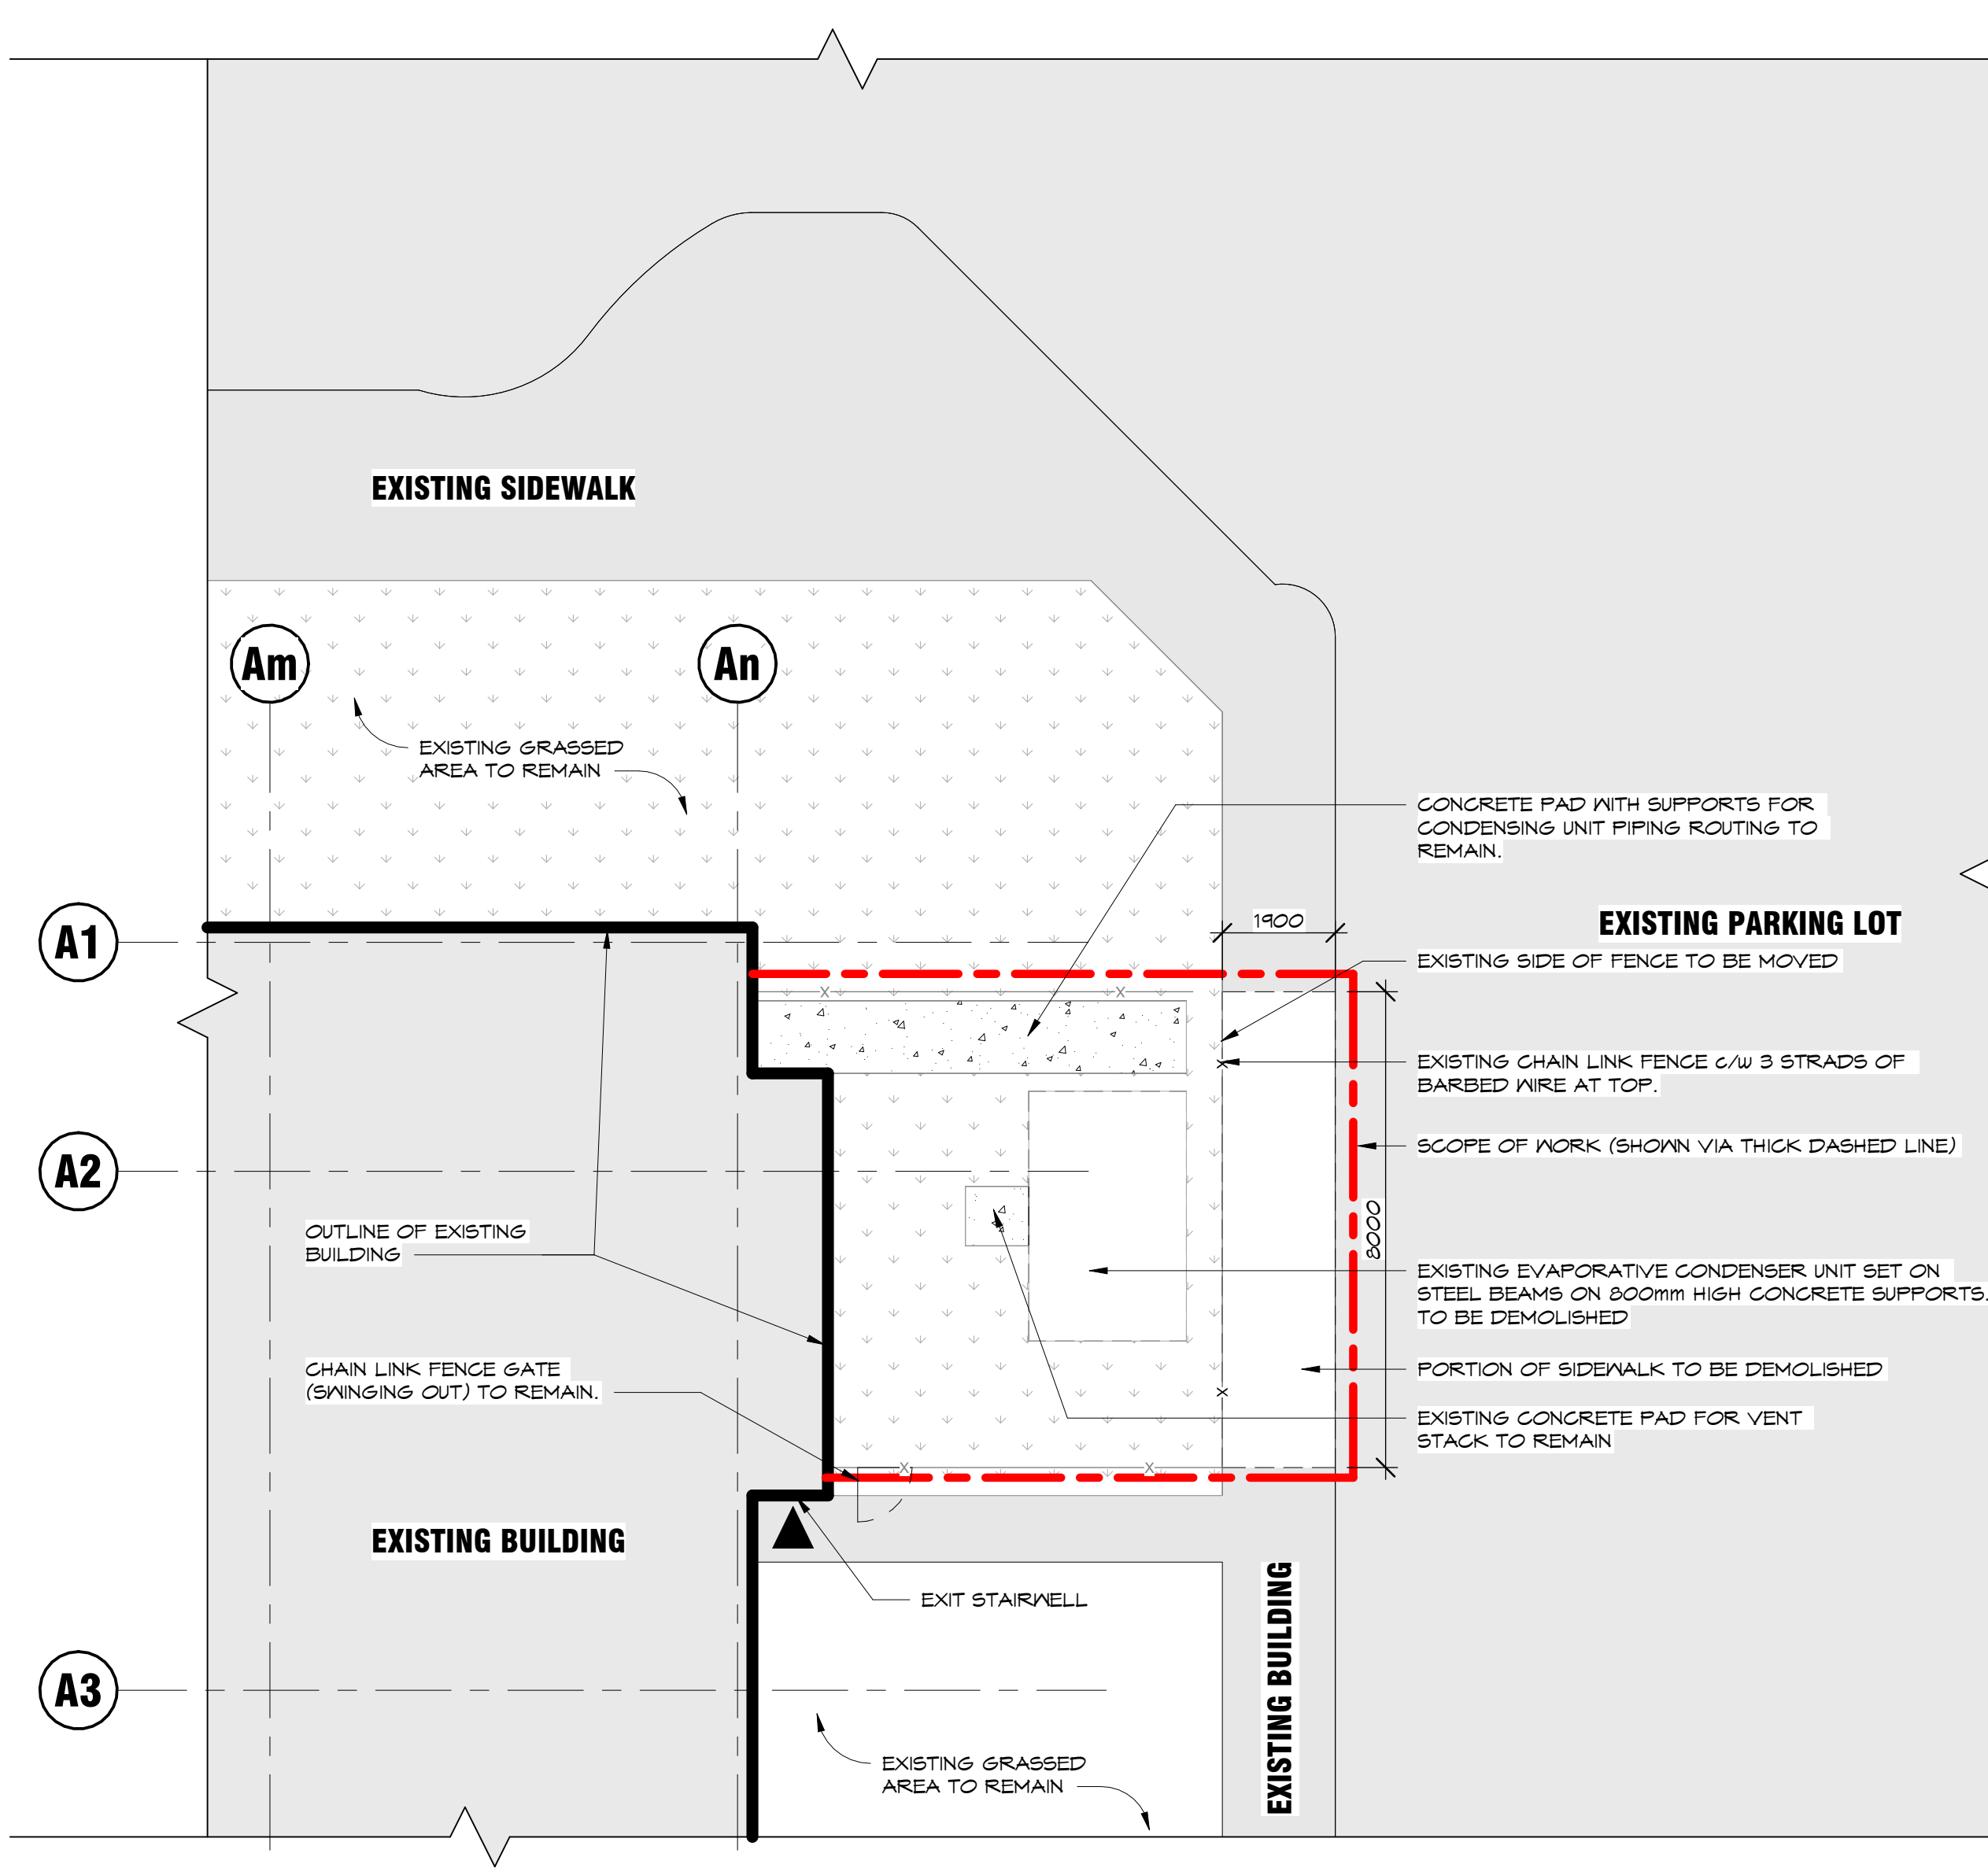


**B1**  
**A2.0** **DEMO SITE PLAN**  
SCALE = 1 : 100

**DEMOLITION PLAN LEGEND**

EXISTING CONSTRUCTION TO REMAIN

EXISTING CONSTRUCTION TO BE REMOVED

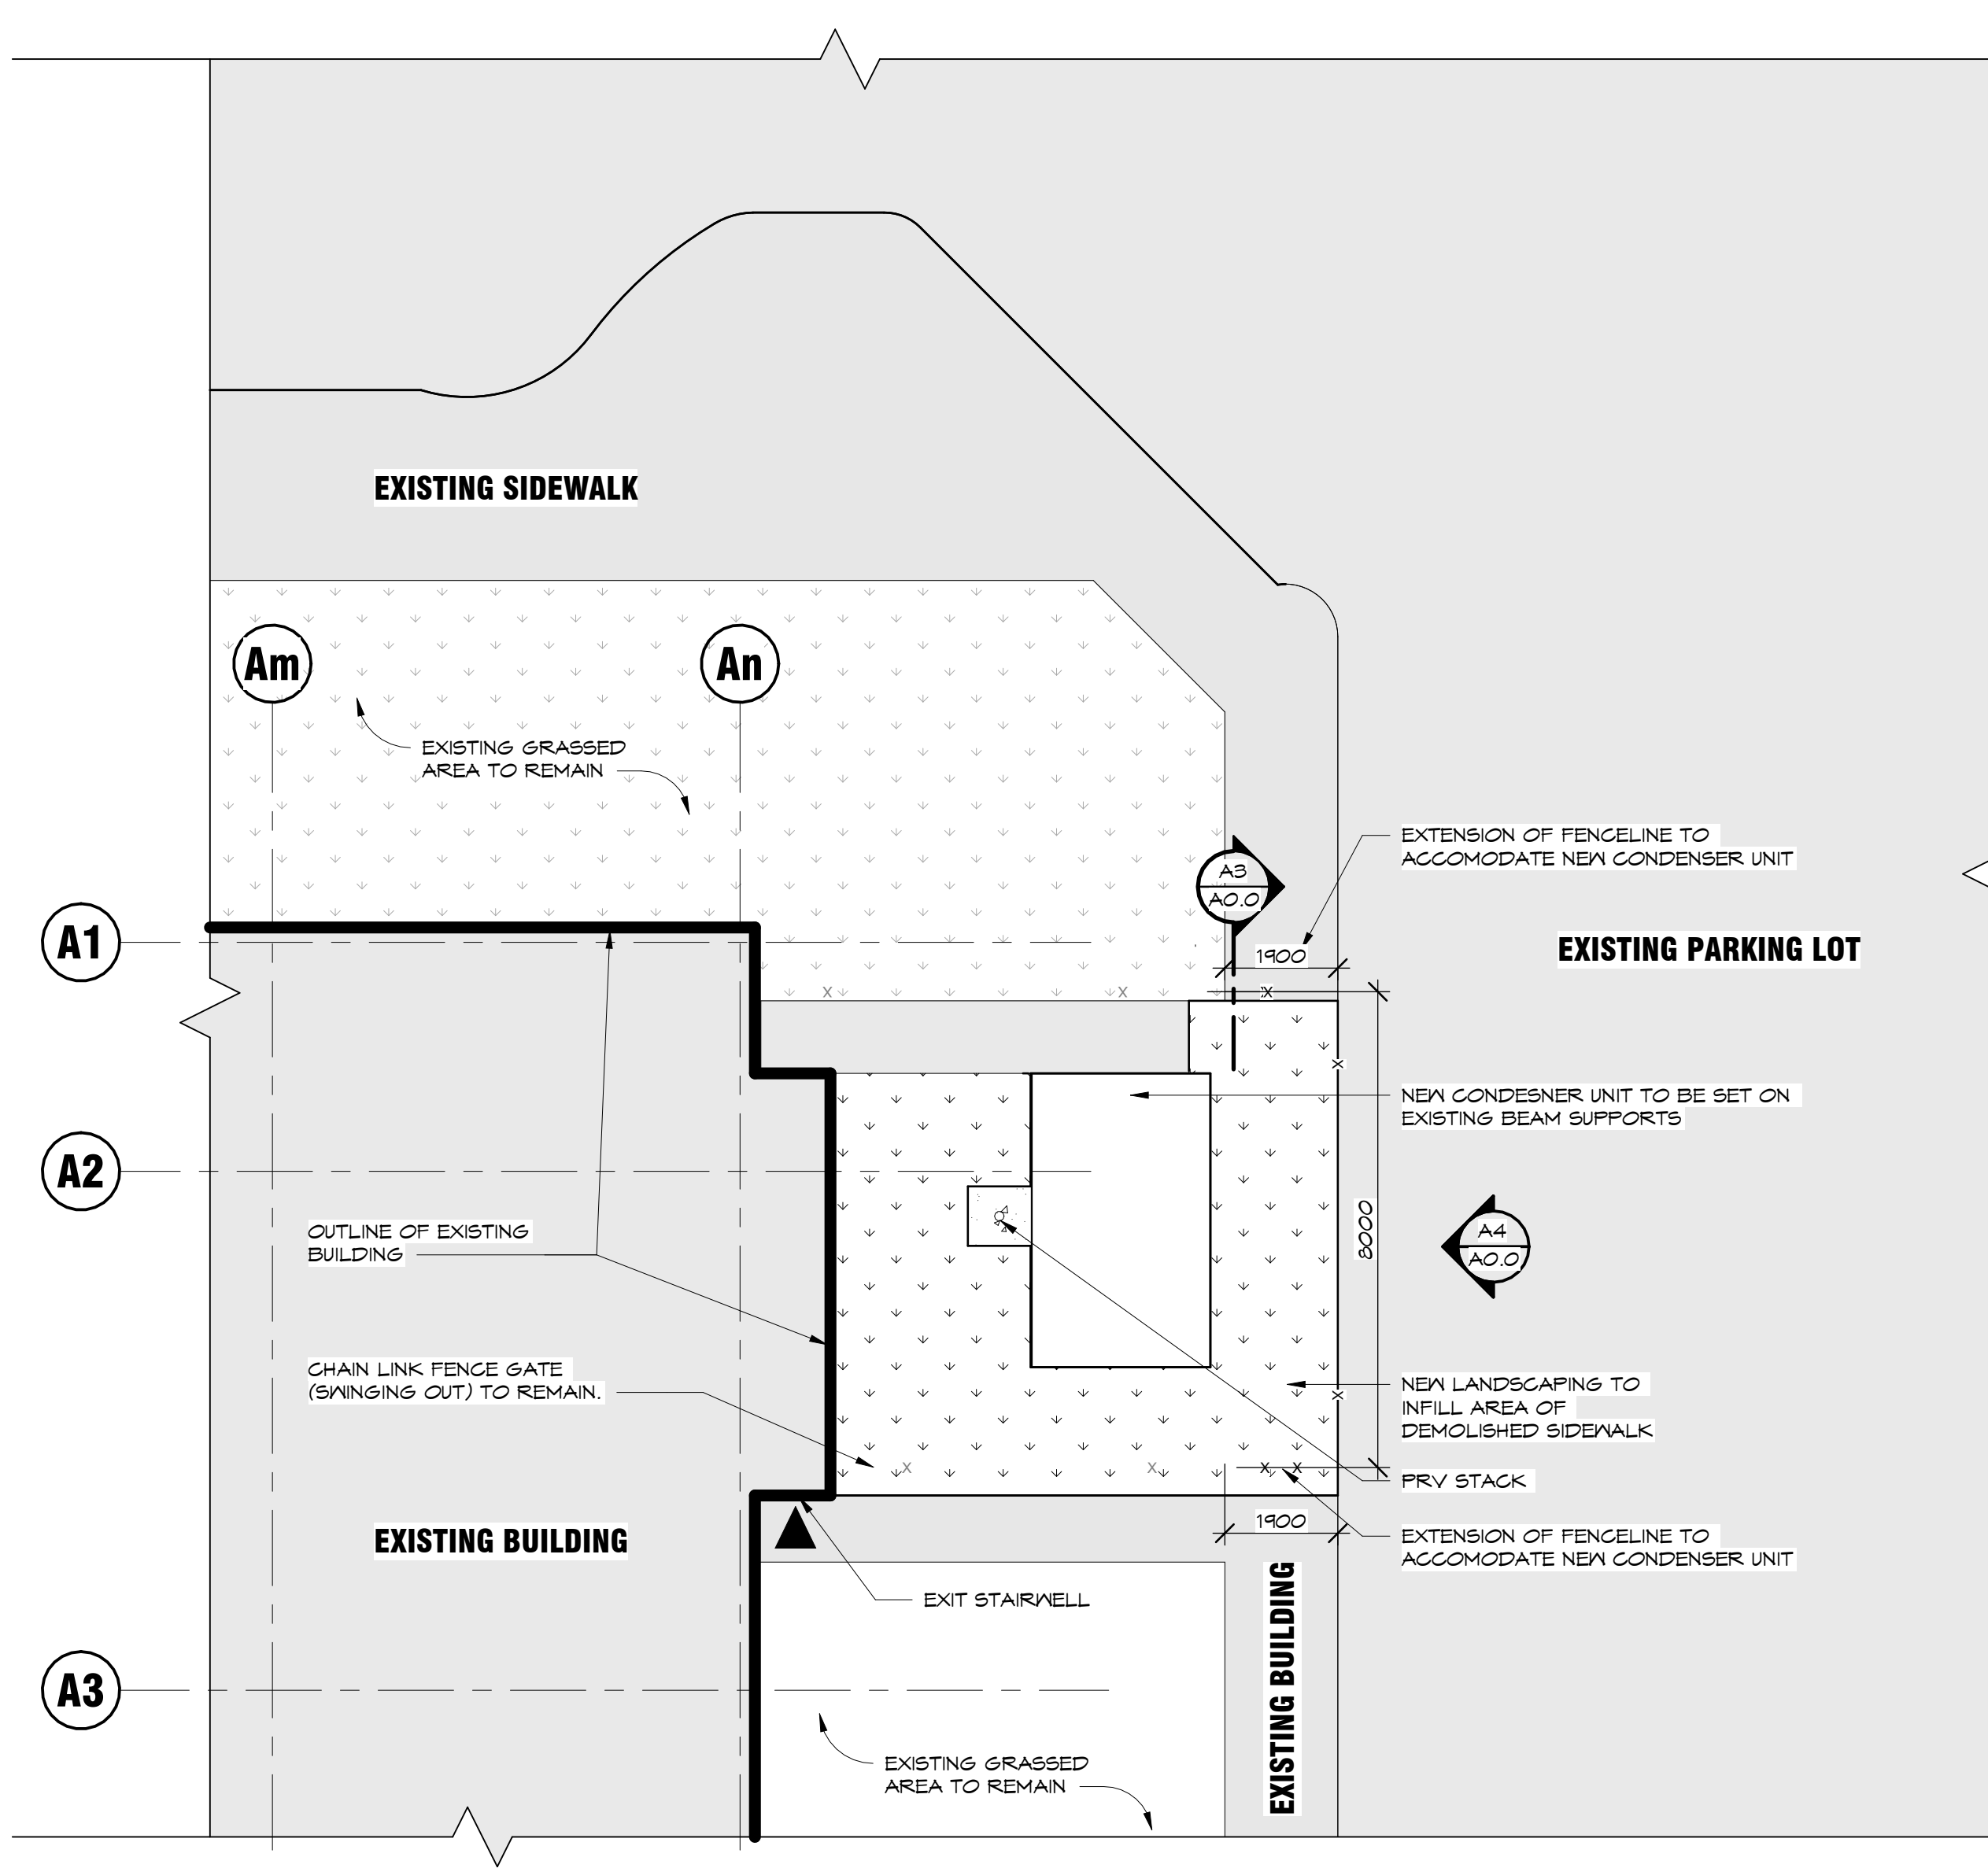

**B3**  
**A2.0** **NEW SITE PLAN**  
SCALE = 1 : 100

**SITE LEGEND**

EXISTING CONSTRUCTION TO REMAIN

NEW CONSTRUCTION

FENCE

GAS LINE

SANITARY LINE

WATER LINE

UNDERGROUND POWER LINE

OVERHEAD POWER LINE

STORM WATER

SITE DRAINAGE DIRECTION

FIRE HYDRANT

MAN HOLE

LIGHT POLE

GRASS